
 




3 GROUND FLOOR DEPARTMENT PLAN

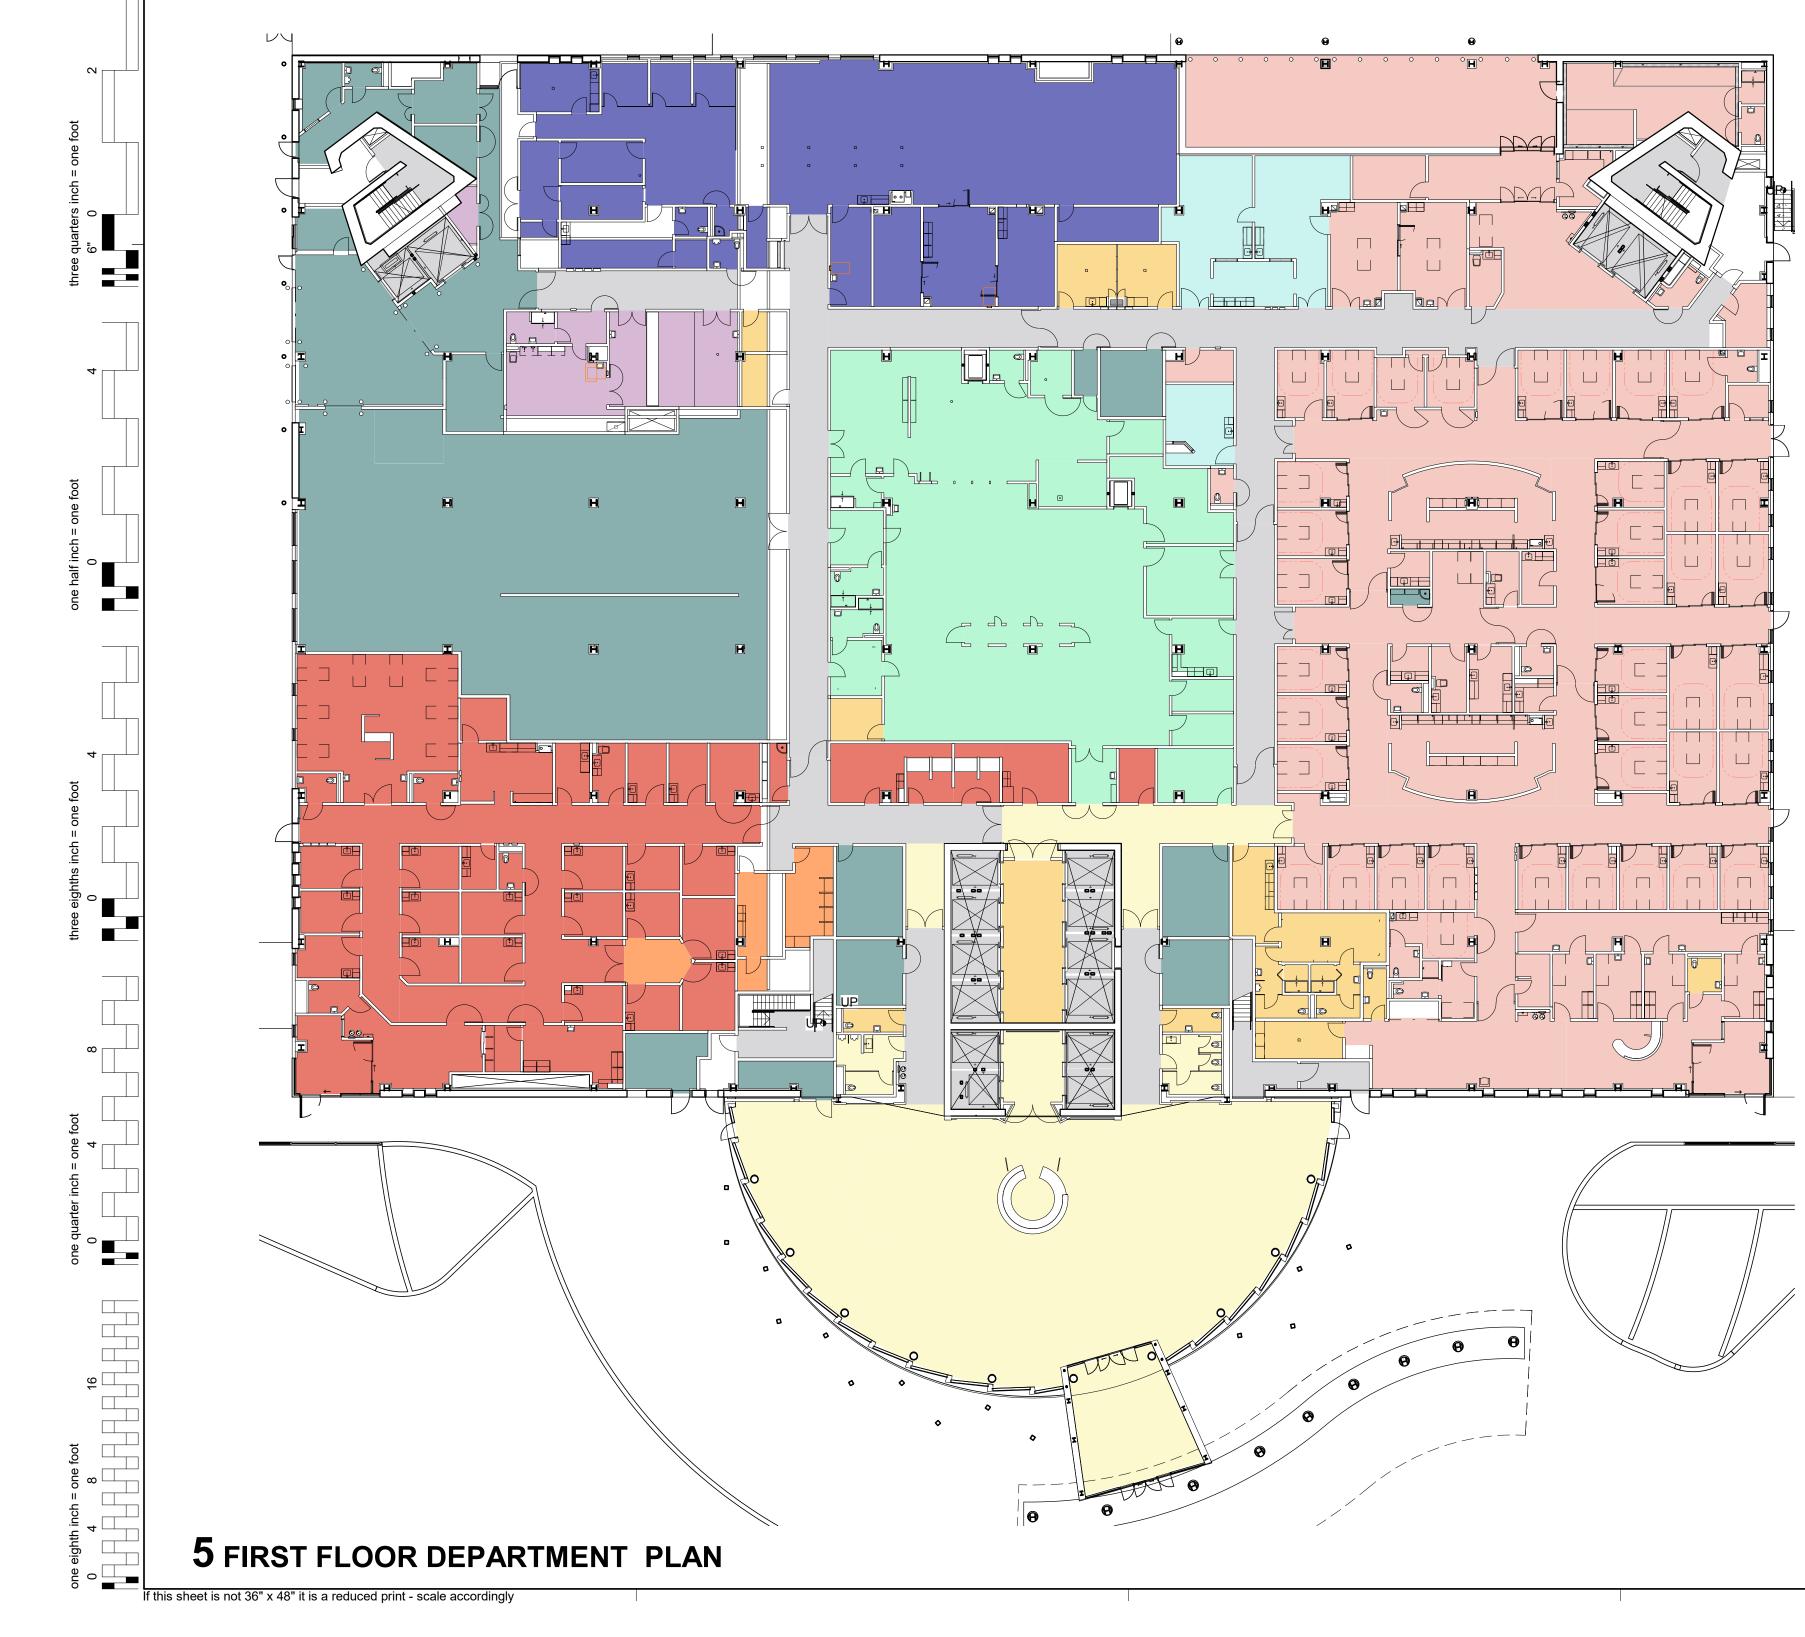





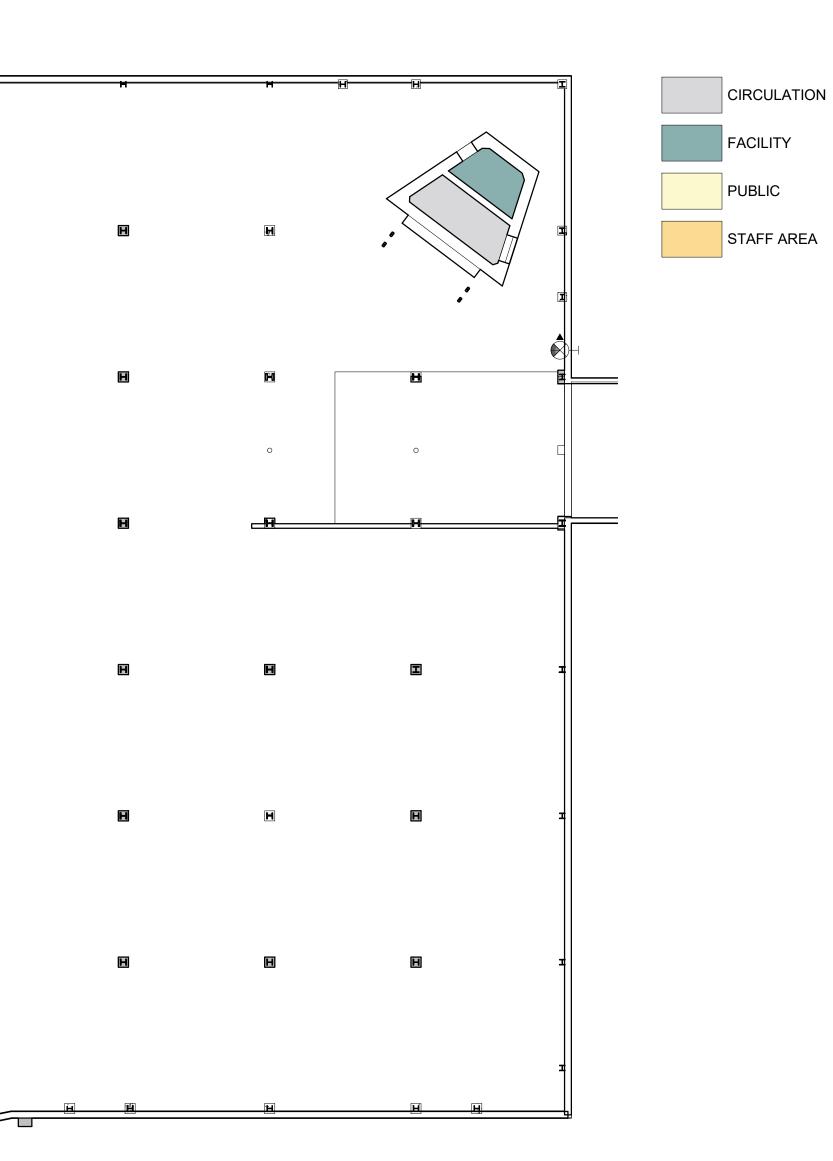

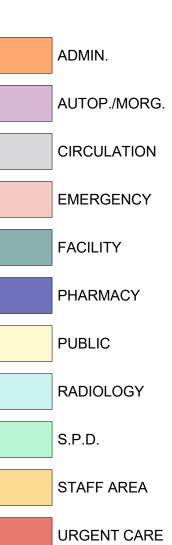



AUTOP./MORG. CIRCULATION EMERGENCY

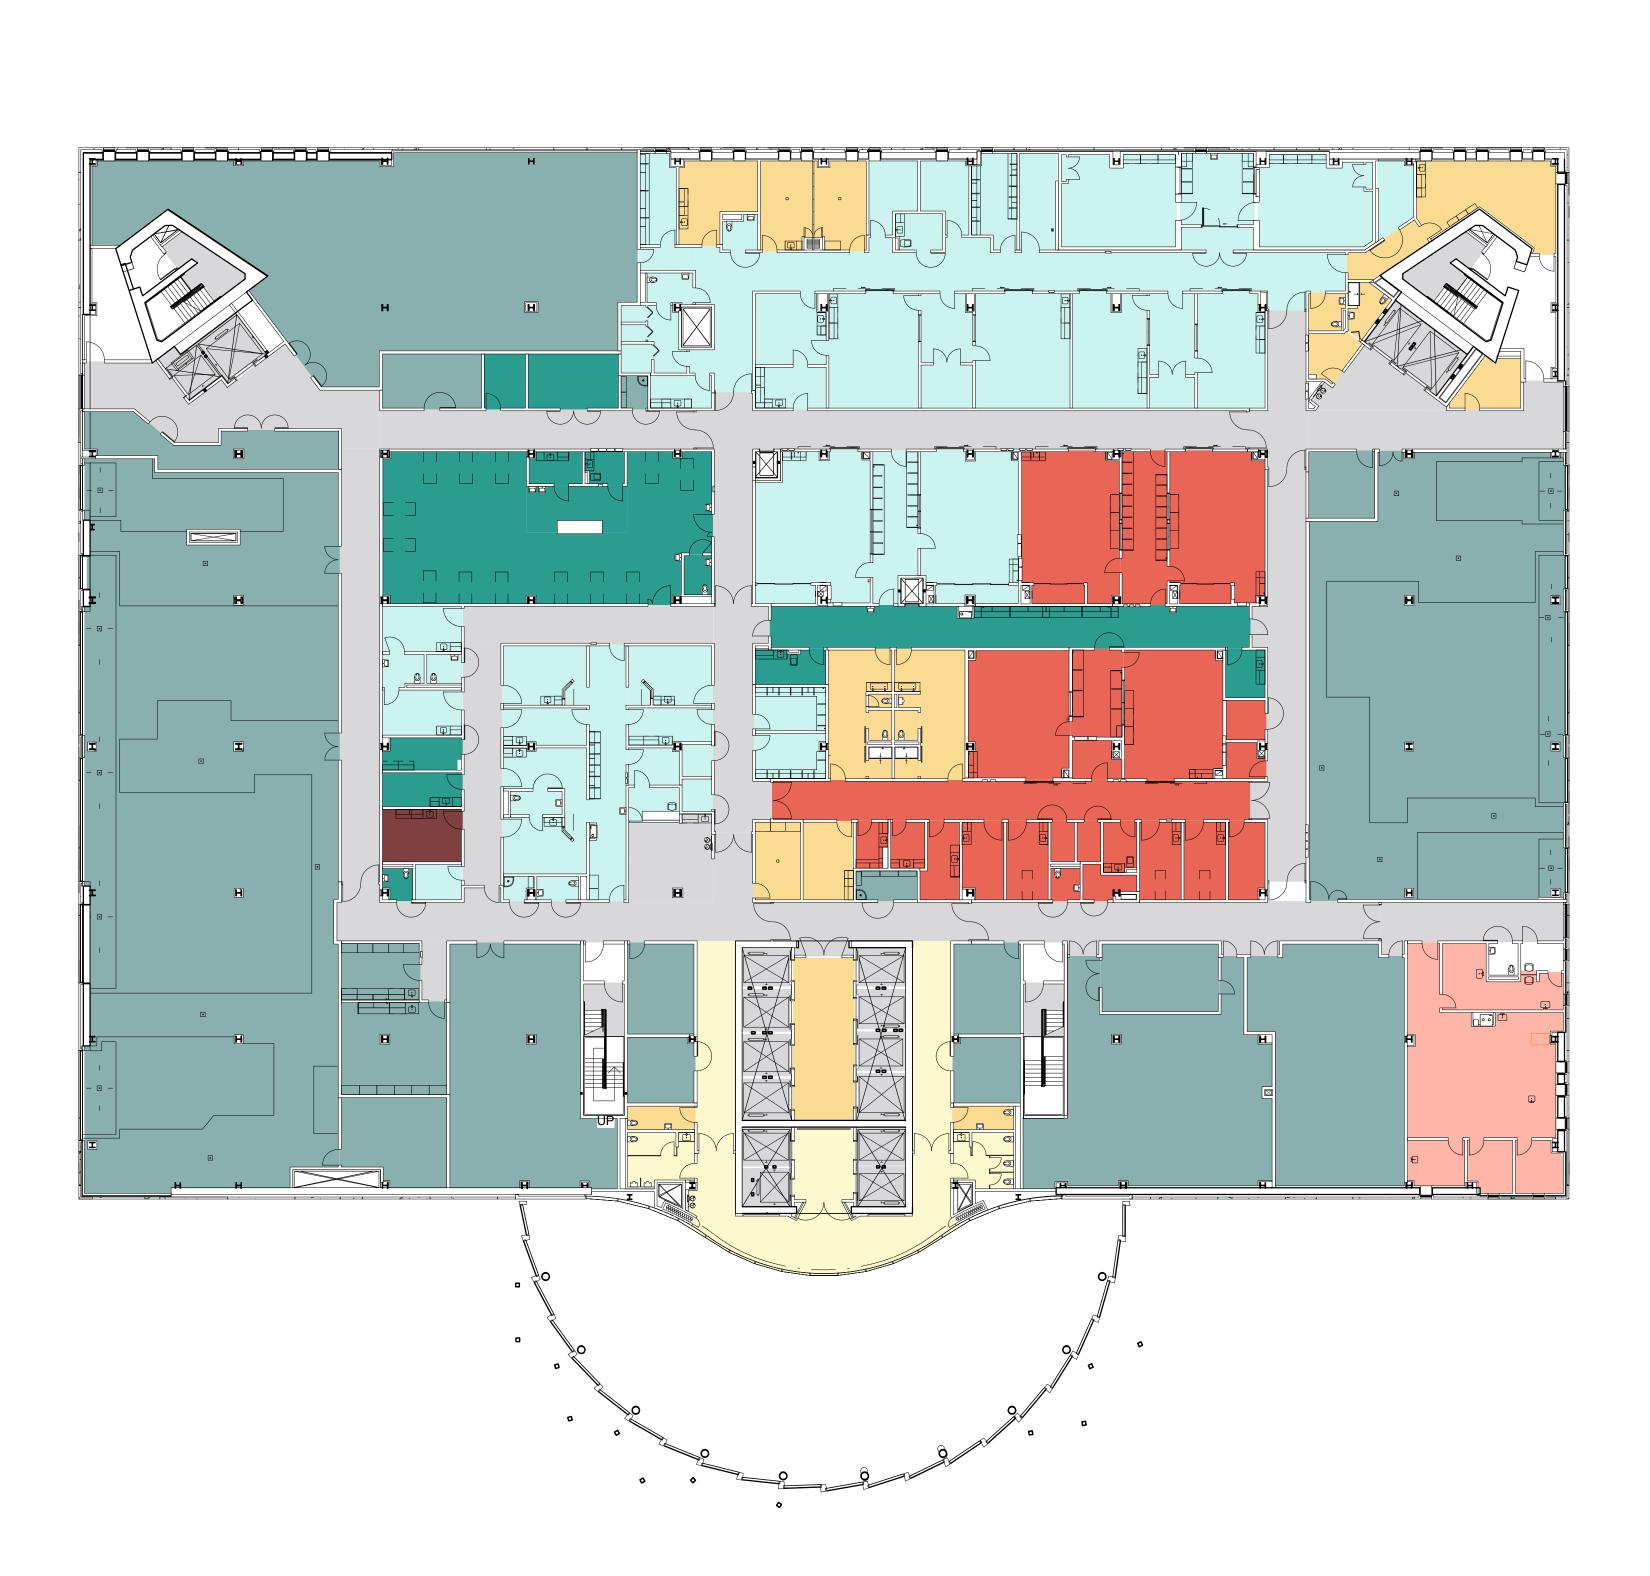

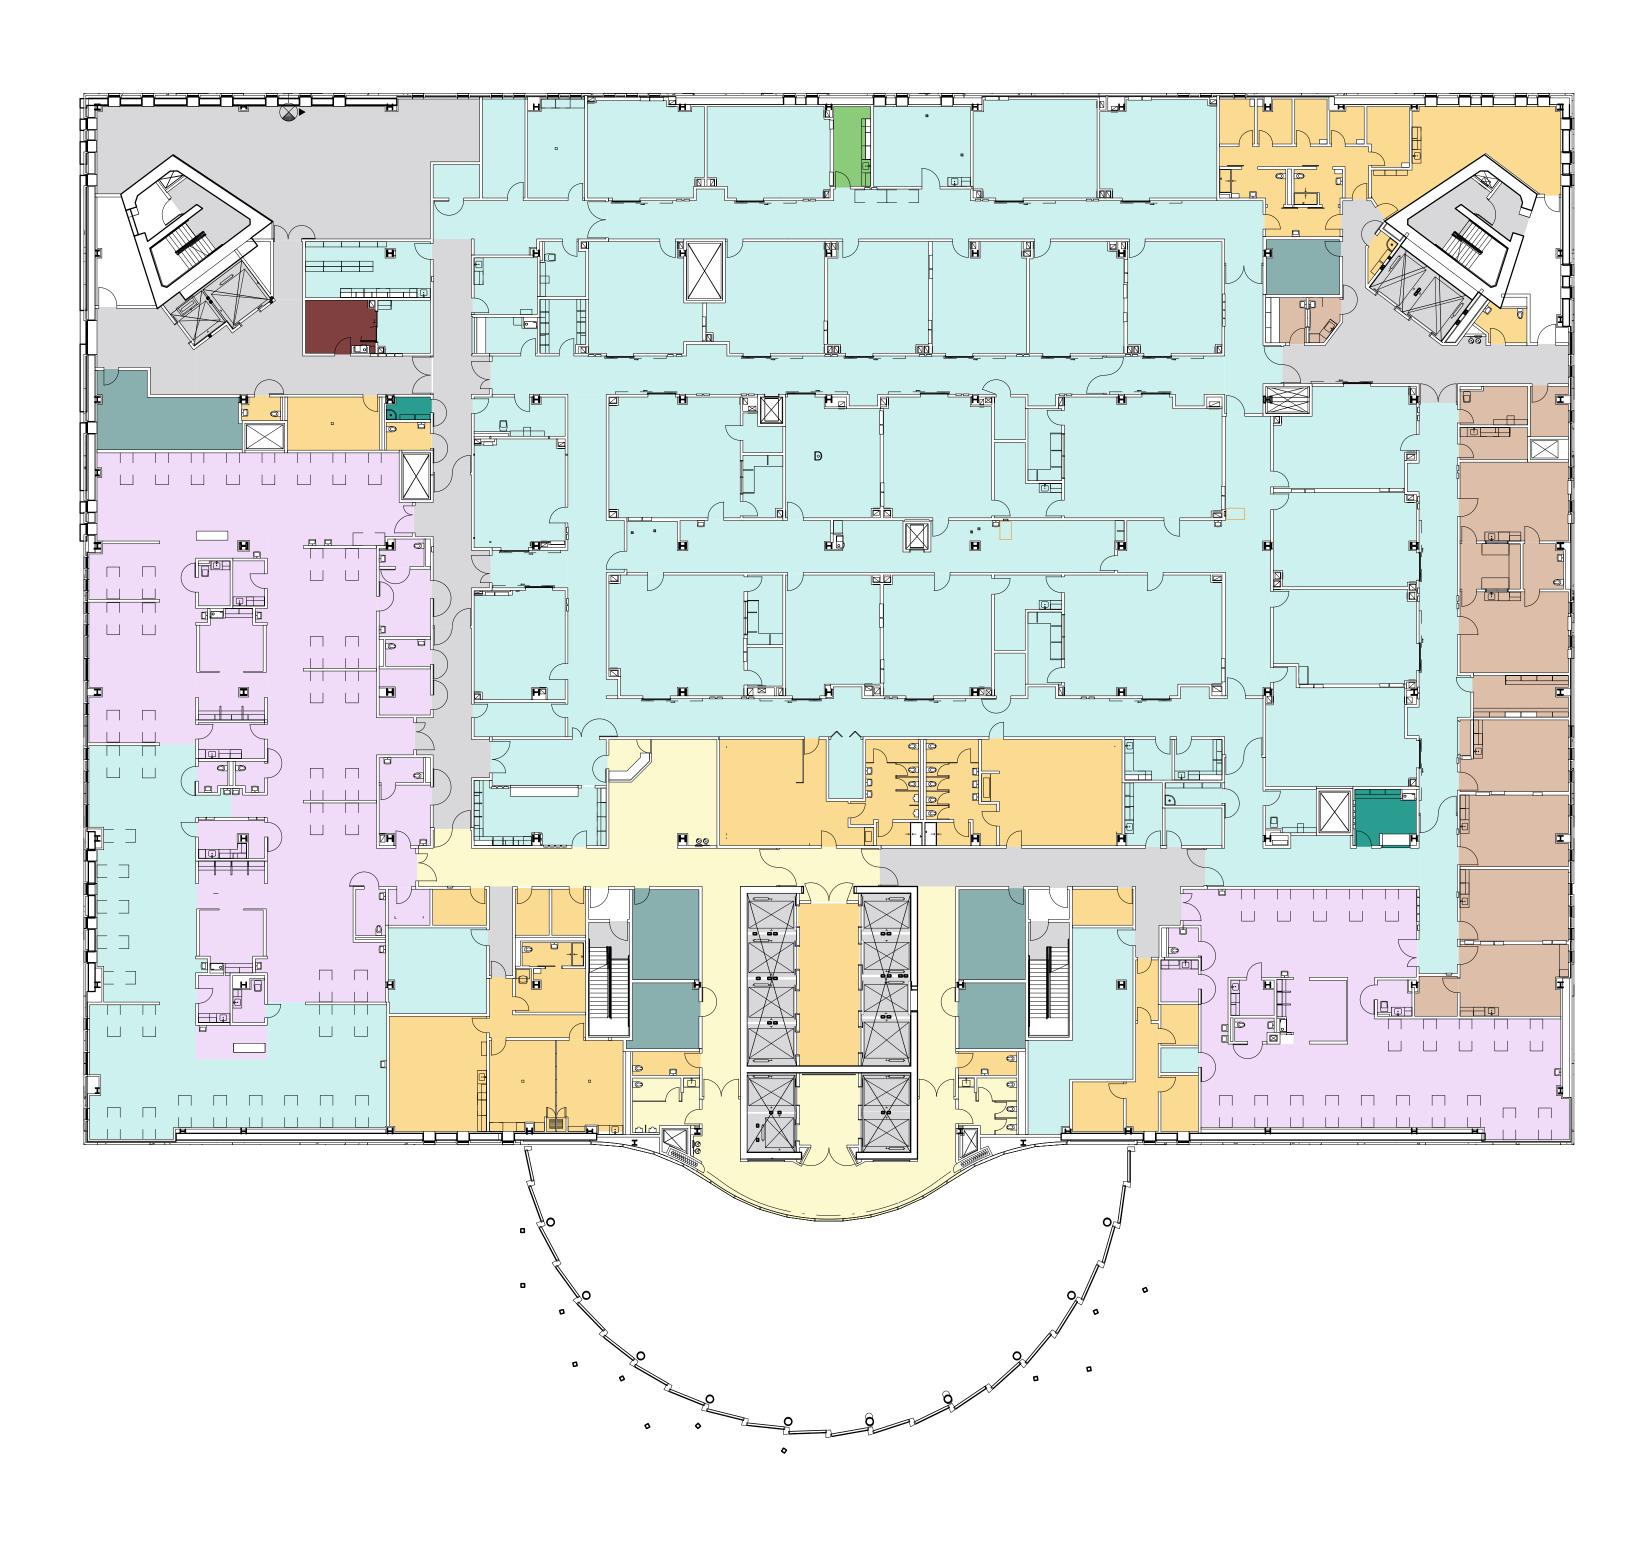

23 SECOND FLOOR DEPARTMENT PLAN

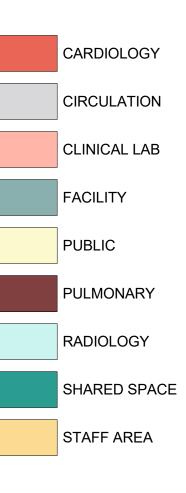

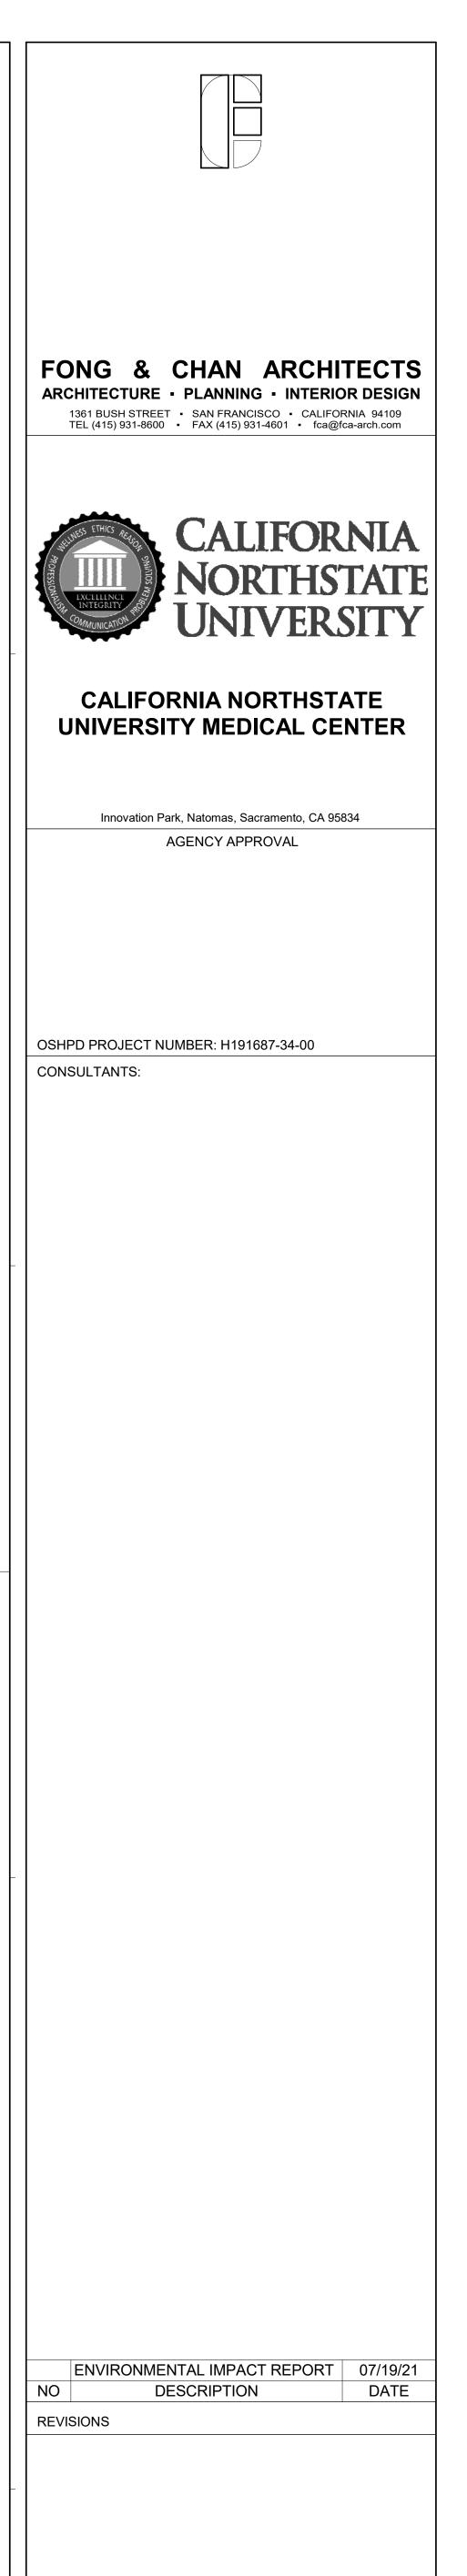

KEY PLAN SHEET TITLE CONCEPTUAL HOSPITAL **FLOOR PLANS**

PROJECT NO. 467 DRAWN BY: FCA

CHECKED BY:


FCA





BIOMED CIRCULATION FACILITY GASTRO. PACU/ PRE-OP PUBLIC PULMONARY SHARED SPACE STAFF AREA

> SCALE: 3/64"=1'-0" DATE: 05/28/21 Plotted on: 7/23/2021 2:43:13 PM

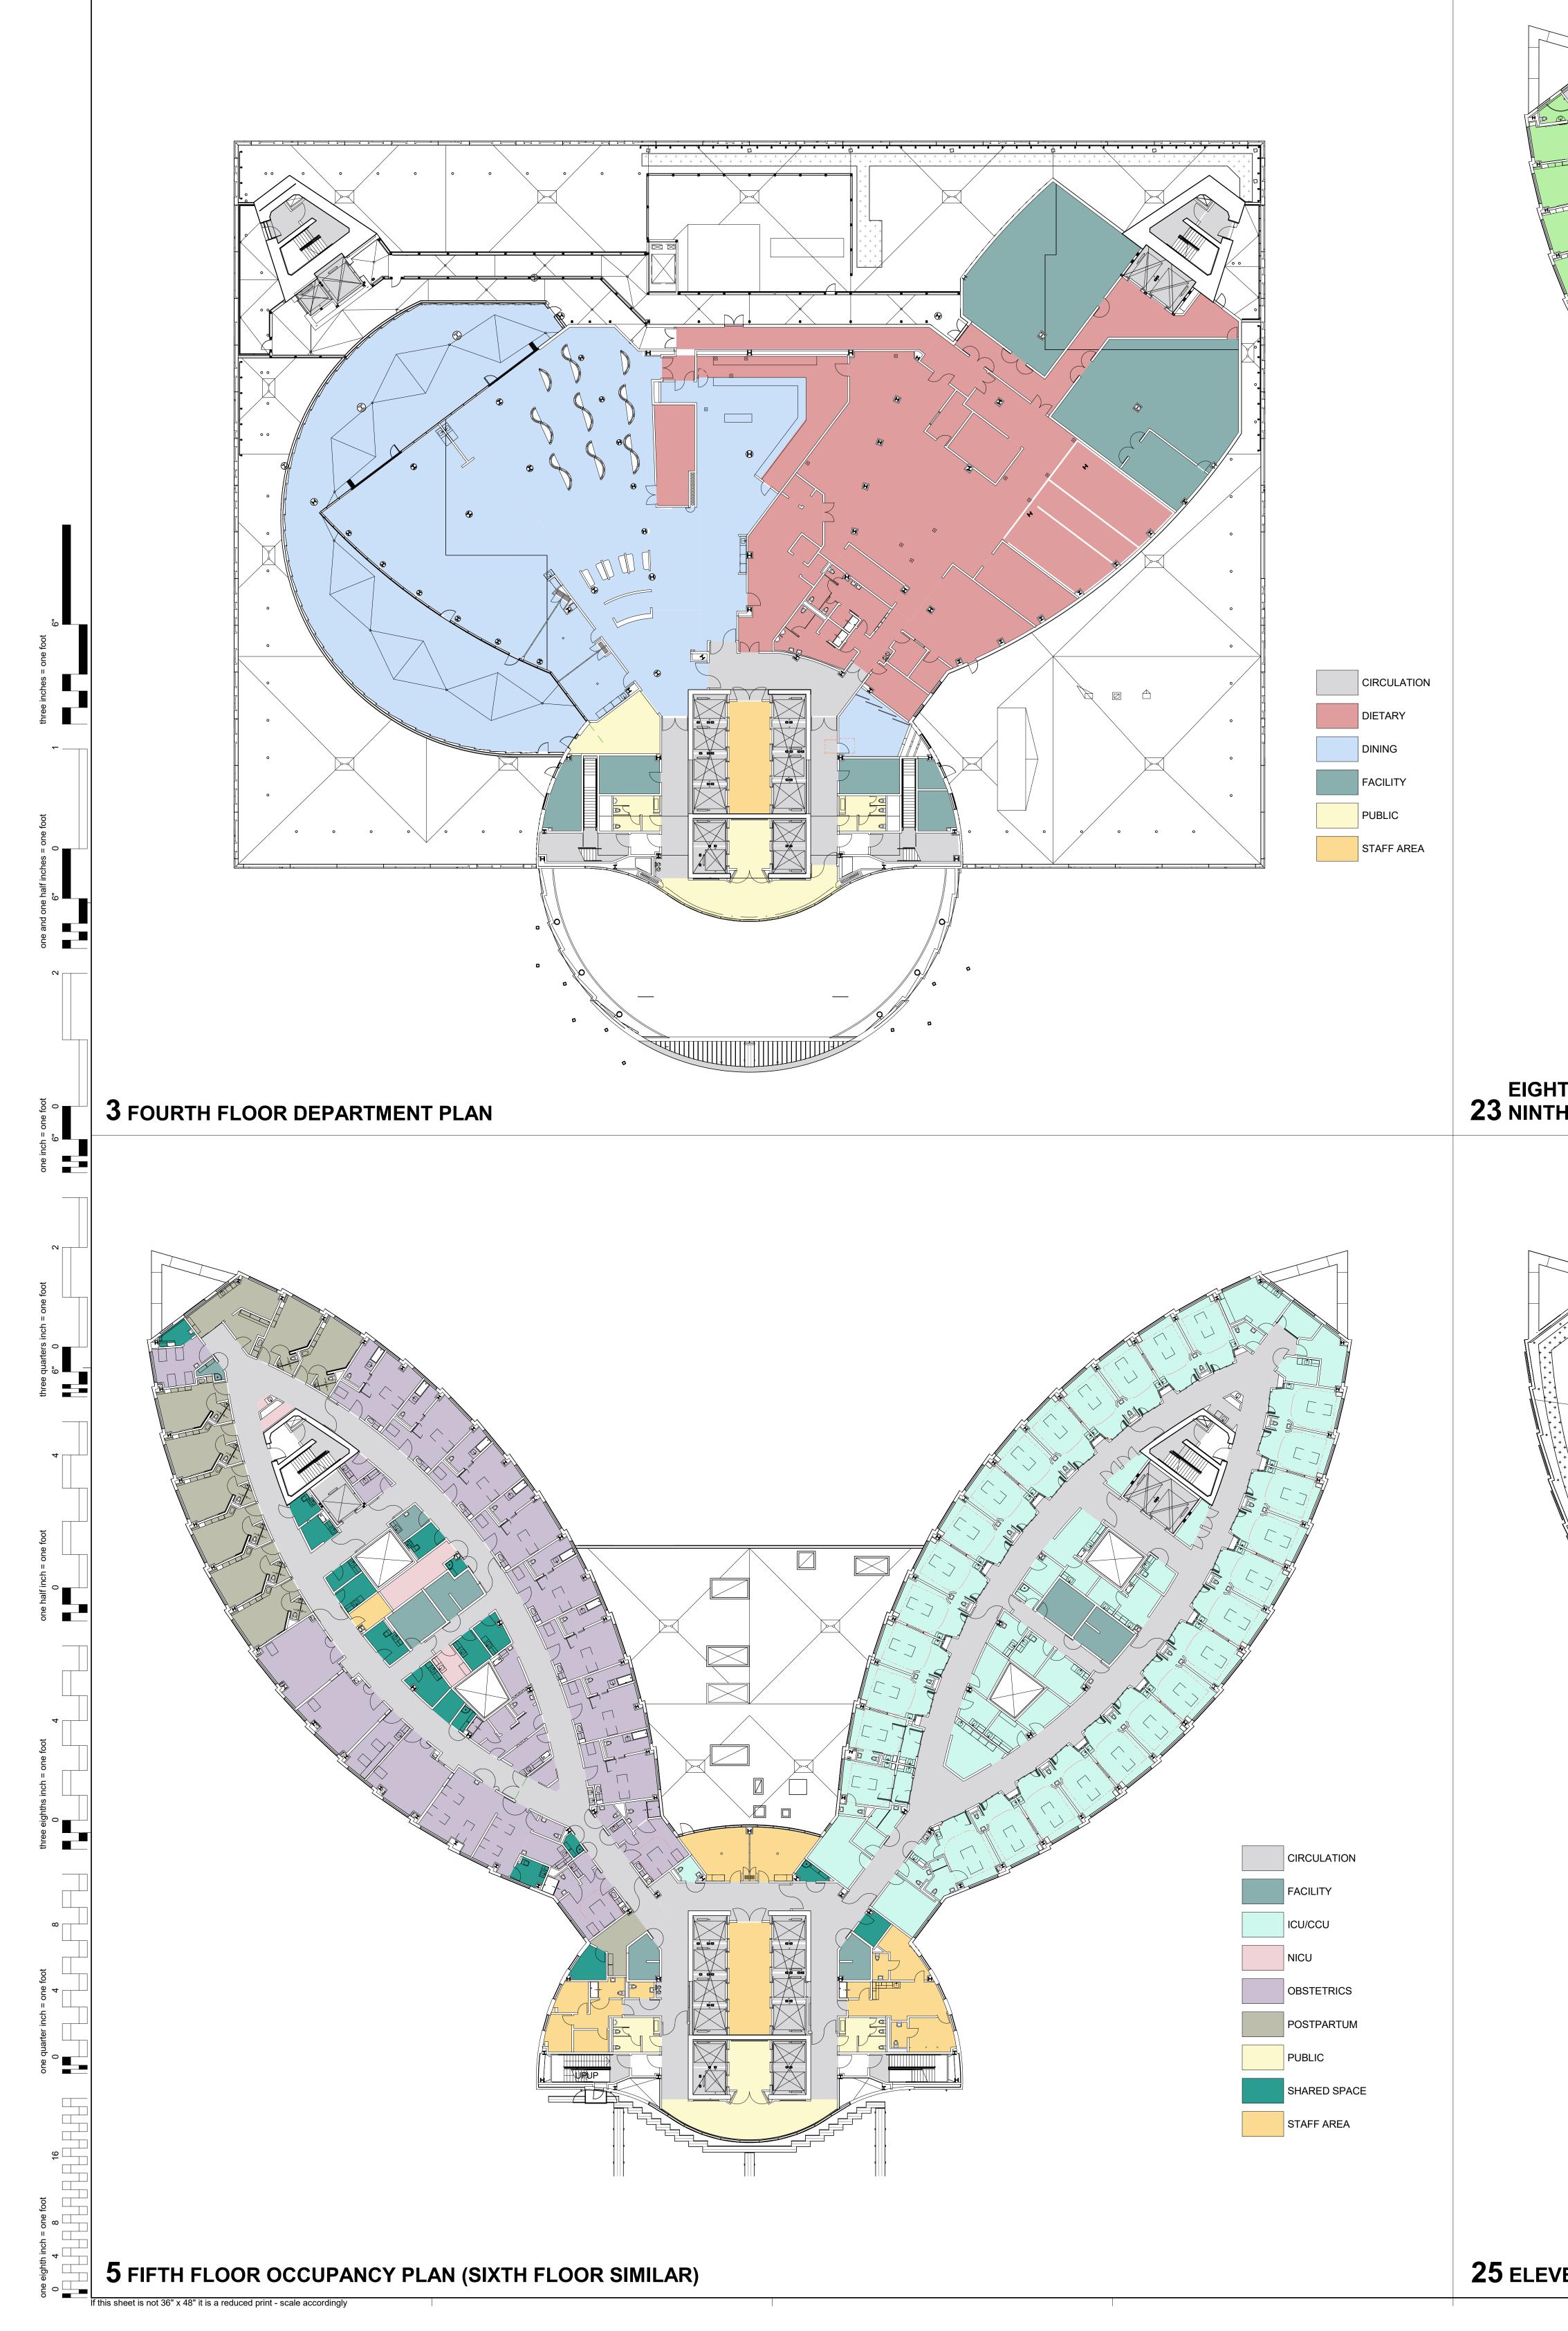

EIGHTH FLOOR DEPARTMENT PLAN (SEVENTH, **23** NINTH, & TENTH FLOORS SIMILAR)

